Service Manual

SERVICE PARTS & DIAGRAMS

BENDPAK

LR-60P

PRODUCT SKU **5175728**

DRAWING Nº

5260168

CATEGORY

Low-Rise Scissor Lift

REV

Version AH

DATE

09.27.2022



BendPak.

This guide is a troubleshooting reference used for maintaining and servicing your Bend Pak product. It provides comprehensive information on identifying serviceable parts and components and assists in troubleshooting problems and performing assembly /disassembly procedures.

BendPak, Inc. Corporate Office

1645 Lemonwood Drive Santa Paula, CA 93060 USA Toll Free US/Canada: 1-800-253-2363 Fax: 1-805-933-9160 info@bendpak.com

Customer Service Desk / Warranty

Customer Service Representatives
Office Tel: 1-805-933-9970
Toll Free US/Canada: 1-800-253-2363
Fax: 1-805-933-9160
customerservice@bendpak.com

Parts Orders

Customer Service Representatives Office Tel: 1-805-933-9970 Toll Free US/Canada: 1-800-253-2363 Fax: 1-805-933-9160 parts@bendpak.com


Domestic Sales & Service

USA Sales Representatives Office Tel: 1-805-933-9970 Toll Free US/Canada: 1-800-253-2363 Fax: 1-805-933-9160 sales@bendpak.com

International Sales & Service

Office Tel: 1-805-933-9970 Exports Dept: 1-805-933-9970 EXT. 192 Ext. Toll Free US/Canada: 1-800-253-2363 Fax: 1-805-933-9160 bpkexports@bendpak.com

	REVISION			
REV	DESCRIPTION	DATE	EDITED BY	ECO#
AF	ADDED POWER UNIT AND REFERENCE NOTE, UPDATED BOM REVISION	12/17/2021	CA	01368
AG	UPDATED BOM REVISION	03/02/2022	CA	01397
АН	UPDATED BOM REVISION	08/16/2022	TM	01433

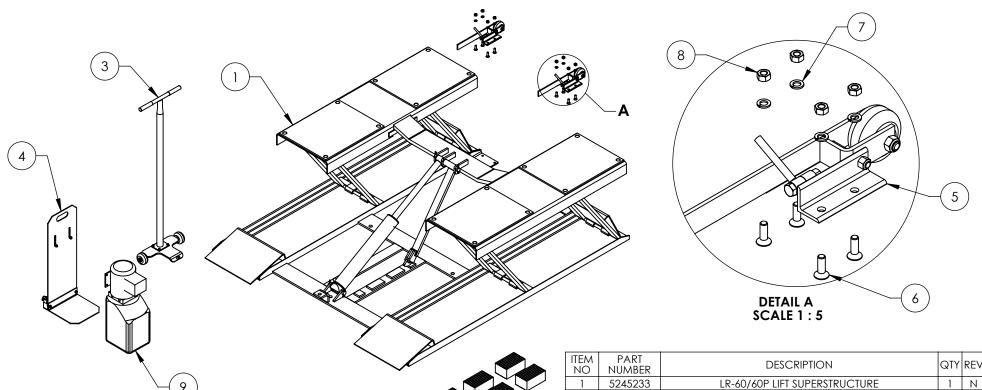

NOTE: UNLESS OTHERWISE SPECIFIED.

- REFER TO MODEL FOR ADDITIONAL INFORMATION
- SEE SHIPPING INSTRUCTIONS FOR FINAL PACKAGING SEE COLORS & GRAPHICS FOR LABEL PLACEMENT 2.

POWER UNIT REFERENCE ON PURCHASE ORDER

ITEM NO	PART NUMBER	DESCRIPTION	QTY	REV
1	5245233	LR-60/60P LIFT SUPERSTRUCTURE	1	Ν
2	5250020	LR-60P PARTS BOX	1	Ν
3	5215871	LOW RISE TOW CART ASSEMBLY	1	С
4	5215983	LOW RISE WHEELED POWER UNIT STAND ASSEMBLY	1	С
5	5210907	LR-60P WHEEL BRACKET ASSEMBLY	2	С
6	5530004	FHPS M10 x 1.5 x 30	8	-
7	5545200	WASHER M10 x Ø18 SL	8	-
8	5535998	NUT M10 x 1.5	8	-
9	REF	POWER UNIT	1	-

DATE



DO NOT SCALE DRAWING

LIFT VER A SIZE DWG. NO. 5260168

PROPRIETARY AND CONFIDENTIAL
THE INFORMATION CONTAINED IN THIS DRAWING IS
THE SOLE PROPERTY OF BENDFAK INC. ANY
REPRODUCTION IN PART OR AS A WHOLE WITHOUT
THE WRITTEN PERMISSION OF BENDPAK INC. IS
PROHIBITED.

NAME

SCALE: 1:24 SHEET 1 OF 2


REV

AΗ

1645 LEMONWOOD DR. SANTA PAULA, CA 93060

LR-60P PRODUCTION

	REVISION			
REV	DESCRIPTION	DATE	EDITED BY	ECO#
L	UPDATED BOM REVISION	11/14/2018	TS	01025
М	REAPLCED 5505350 WITH 5505400, ADDED 5715035 AND 5530366, ADDED LOCK HEIGHTS (pg2), UPDATED BOM REVISIONS	09/20/2019	СА	01128
Z	REPLACED 5715035 WITH 5715048, 5530366 WITH 5530364, ADDED 5535357, MOVED DIMENSION PAGE TO TOP LEVEL DRAWING, UPDATED BOM REVISION	07/29/2022	TM	01433

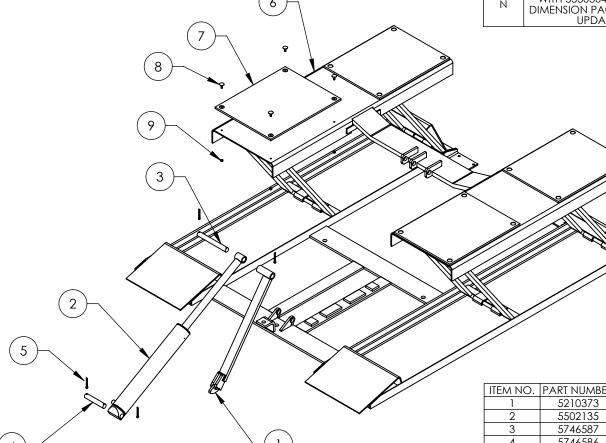

WHERE USED LR-60 SERIES

NOTE: UNLESS OTHERWISE SPECIFIED.

- REFER TO MODEL FOR ADDITIONAL INFORMATION
- 2. 3. SEE COLORS & GRAPHICS FOR LABEL PLACEMENT SEE SHIPPING INSTRUCTIONS FOR FINAL PACKAGING

ASSEMBLE ITEMS AS SHOWN

ITEM NO.	PART NUMBER	DESCRIPTION	QTY.	REV
1	5210373	LR-60/60P SAFETY BAR ASSEMBLY	1	D
2	5502135	CYLINDER ASSEMBLY Ø3.0 X 18	1	Е
3	5746587	UPPER HINGE PIN	1	В
4	5746586	DLR-6/LR-60 LOWER CYLINDER PIN	1	В
5	5505400	COTTER PIN Ø6 x 50mm	4	-
6	5600526	LR-60 LIFT WELDMENT	1	K
7	5715048	DLR-6, LR-60 RAMP BOLT-ON RUBBER PAD	4	Α
8	5530364	ELEVATOR BOLT M6 x 1.0 x 25	16	Α
9	5535357	NUT M6 x 1.0 NL	16	В

DO NOT SCALE DRAWING NAME DATE DRAWN TM 10/04/2010 CHECKED OR 08/26/2022 DIMENSIONS ARE IN MM THIRD ANGLE PROJECTION TITLE:

NEXT ASSEMBLY

5260167

5260168





LR-60/60P LIFT SUPERSTRUCTURE

PROPRIETARY AND CONFIDENTIAL THE INFORMATION CONTINUENTIAL
THE INFORMATION CONTINUED IN THIS DRAWING IS
THE SOLE PROPERTY OF BENDPAK INC. ANY
REPRODUCTION IN PART OR AS A WHOLE WITHOUT
THE WRITTEN PERMISSION OF BENDPAK INC. IS
PROHIBITED.

	SIZE	DWG. NO.		REV
S	Α	5245233		Ν
1		SCALE: 1:20	SH	EET 1 OF

 1645 LEMONWOOD DR. SANTA PAULA, CA 93060



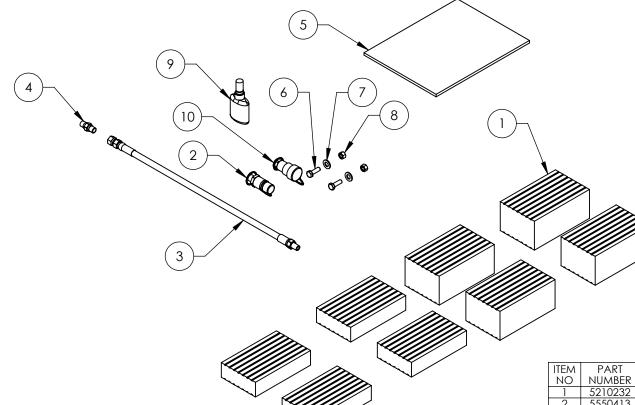

NO WELL	PART NUMBER	DESCRIPTION	QTY	REV
1	5210232	LOW RISE SCISSOR LIFT RUBBER PAD KIT, SET OF 8	1	Α
2	5550413	FTG NPL -06 ORB x 1/4 NS; QUICK-CON COUP MALE	1	-
Ω	5570244	HYDRAULIC HOSE ASSEMBLY Ø6.4 x 2873mm DS-M	1	Α
4	5550147	FTG NPL -04 JIC x -04 NPT	1	-
5	5900337	LR-60/60P INSTALLATION MANUAL	1	-
6	5530010	HHB M8 x 1.25 x 25	2	-
7	5545341	WASHER M10 x Ø20 FLAT	2	-
8	5535001	NUT M8 x 1.25 NL	2	-
9	5580012	LIQUID PTFE THREAD SEALANT 50ml	1	-
10	5550031	FTG NPL-04 NPT F x 1/4 QUICK-CONNECTOR COUPLER FEMALE; NON SPILL DESIGN	1	-

DO NOT SCALE DRAWING NAME DATE DRAWN 10/05/2010 TM CHECKED DIMENSIONS ARE IN MM THIRD ANGLE PROJECTION TITLE:



LR-60P PARTS BOX

1645 LEMONWOOD DR.

SANTA PAULA, CA 93060

PROPRIETARY AND CONFIDENTIAL
THE INFORMATION CONTAINED IN THIS DRAWING IS
THE SOLE PROPERTY OF BENDFAK INC. ANY
REPRODUCTION IN PART OR AS A WHOLE WITHOUT
THE WRITTEN PERMISSION OF BENDPAK INC. IS
PROHIBITED.

SIZE DWG. NO. 5250020 SCALE: 1:6


Ν SHEET 1 OF 1

REV


NOTE: UNLESS OTHERWISE SPECIFIED. SEE SHIPPING INSTRUCTIONS FOR FINAL PACKAGING

NEXT ASSEMBLY 5260168

WHERE USED LR-60P

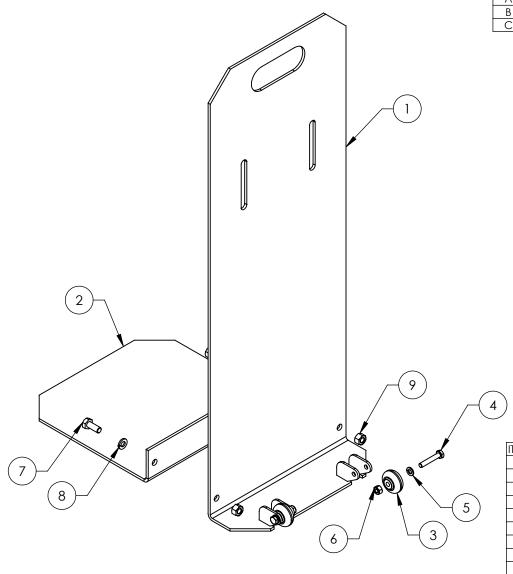

	REVISION			
REV	DESCRIPTION	DATE	EDITED BY	ECO#
Α	PRODUCTION RELEASE	08/11/2020	TM	01188
В	UPDATED BOM REVISION AND NEXT ASSEMBLY	12/17/2021	CA	01368
С	UPDATED BOM REVISION	03/02/2022	CA	01397

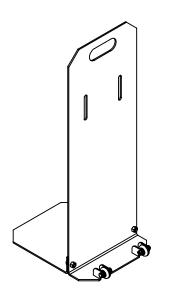

ISOMETRIC VIEW FOR REFERENCE ONLY DO NOT SCALE

ITEM NO	PART NUMBER	DESCRIPTION	QTY	REV
1	5601407	LOW RISE POWER UNIT STAND WELDMENT	1	D
2	5737141	LOW RISE POWER UNIT STAND EXTENSION PLATE	1	В
3	5716192	QUICKJACK POLYURETHANE WHEEL	2	Е
4	5530027	HHB M6 x 1.0 x 35	2	
5	5545026	WASHER M6 x Ø12 SL	2	
6	5535357	NUT M6 x 1.0 NL	2	
7	5530304	HHB M8 x 1.25 x 20mm	2	
8	5545202	WASHER M8 x Ø15 SL	2	
9	5535001	NUT M8 x 1.25 NL	2	

DO NOT SCALE DRAWING		NAME	DATE
	DRAWN	TM	08/10/2020
	CHECKED	OR	03/02/2022
DIMENSIONS ARE IN MM	THIRD AN	ICI E DDC	LICTION

1645 LEMONWOOD DR. SANTA PAULA, CA 93060

NEXT ASSEMBLY

5260168

5260630

5260632

5260652

THIRD ANGLE PROJECTION	

LOW RISE WHEELED POWER UNIT STAND ASSEMBLY

SIZE DWG. NO. REV С 5215983 **SCALE: 1:5** SHEET 1 OF 1

NOTE: UNLESS OTHERWISE SPECIFIED.


WHERE USED LR-60P

> MD-6XP DLR-6P


DMR-6

- REFER TO MODEL FOR ADDITIONAL INFORMATION SEE SHIPPING INSTRUCTIONS FOR FINAL PACKAGING

PROPRIETARY AND CONFIDENTIAL
THE INFORMATION CONTAINED IN THIS DRAWING IS
THE SOLE PROPERTY OF BENDFAK INC. ANY
REPRODUCTION IN PART OR AS A WHOLE WITHOUT
THE WRITTEN PERMISSION OF BENDPAK INC. IS
PROHIBITED.

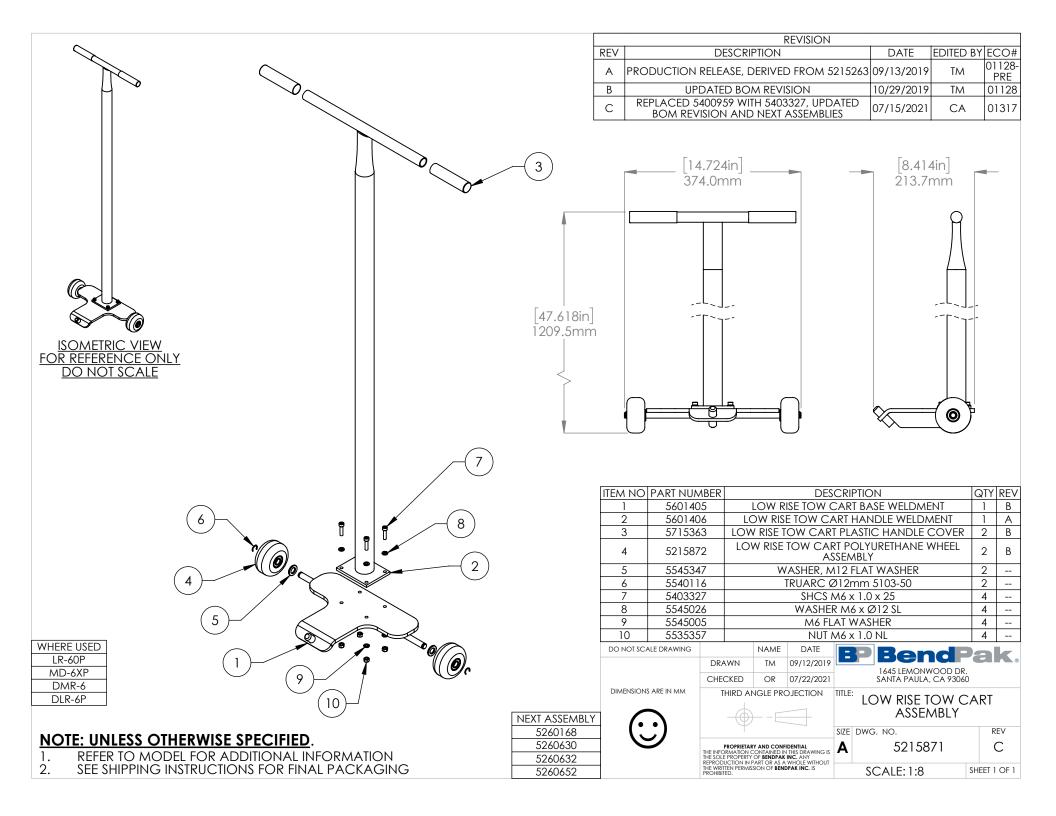

		REVISION			
	REV	DESCRIPTION	DATE	EDITED BY	ECO#
Ī	Α	PRODUCTION RELEASE, DERIVED FROM 5210944	09/18/2019	TM	01128

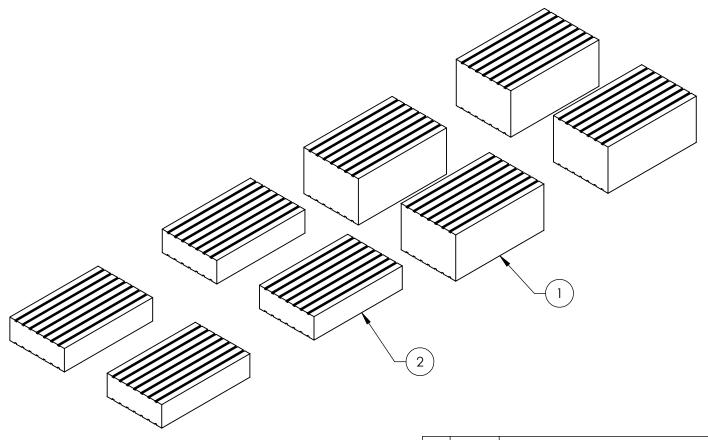


WHERE USED
LR-60 SERIES
DLR-6 SERIES
MDS-6 SERIES
P9000LT SERIES
SP-7XE SERIES

NOTE: UNLESS OTHERWISE SPECIFIED.

- REFER TO MODEL FOR ADDITIONAL INFORMATION SEE SHIPPING INSTRUCTIONS FOR FINAL PACKAGING 2.

ITEM NO	PART NUMBER	DESCRIPTION	QTY	REV
1	5300862	LOW RISE SCISSOR LIFT 75mm RUBBER PAD KIT, SET OF 4	1	Α
2	5300861	LOW RISE SCISSOR LIFT 38mm RUBBER PAD KIT, SET OF 4	1	Α


NEXT ASSEMBLY	DO NOT SCALE DRAWING		NAME	DATE
ACCESSORY		DRAWN	TM	09/18/201
5250020		DRAWN	11//1	09/10/201
5250021		CHECKED	CA	11/01/201
5250034	DIMENSIONS ARE IN MM	THIRD AN	ICI E PRO	DJECTION
5250054		THIRD / II	VOLL I KC)JEC IIOI V
5250062				
5250063	()			
5250064		T		
5250110		DD ODDIETA D	Y AND CONFI	DENTIAL
5250174		THE INFORMATION C	ONTAINED IN	THIS DRAWING
5250317		REPRODUCTION IN F		

 


LOW RISE SCISSOR LIFT RUBBER PAD KIT, SET OF 8

1645 LEMONWOOD DR. SANTA PAULA, CA 93060

SIZE DWG. NO. REV PROPRIETARY AND CONFIDENTIAL
THE INFORMATION CONTAINED IN THIS DRAWING IS
THE SOLE PROPERTY OF BEDYAK INC. ANY
REPRODUCTION IN PART OR AS A WHOLE WITHOUT
THE WRITTEN PERMISSION OF BENDPAK INC. IS
PROHIBITED. 5210232 Α SCALE: 1:5 SHEET 1 OF 1

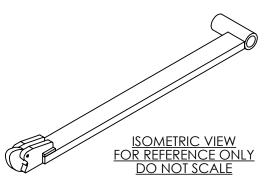

	REVISION						
REV	DESCRIPTION	DATE	EDITED BY	ECO#			
В	UPDATED BOM REVISION	09/18/2015	JM	00726			
C	UPDATED BOM REVISION	09/18/2018	TM	00996			
D	UPDATED BOM REVISION	11/14/2018	TS	01025			

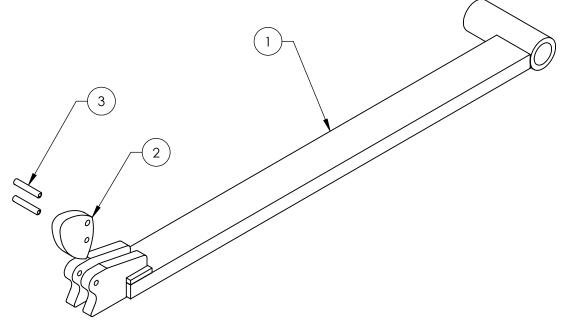

ITEM NO	PART NUMBER			DE	SCRIPTION	QTY	REV
1	5210372		LR-60/60P SAFETY BAR WELDMENT		1	С	
2	5736676		DLR-6/LR-60 SAFETY LATCH		1	Е	
3	5505141			SPRIN	G PIN M6 x 36	2	
DO NOT SCALE DRAWING			NAME	DATE	BP BendPa	ak	
		DDAMAL	TC	04/14/0014			

DO NOT SCALE DRAWING

DRAWN
TS
04/14/2014

CHECKED
CA
11/26/2018

THIRD ANGLE PROJECTION

TITLE:

SIZE

LR-60/60P SAFETY BAR ASSEMBLY

SIZE DWG. NO. REV
5210373 D

1645 LEMONWOOD DR. SANTA PAULA, CA 93060

PROPRIETARY AND CONFIDENTIAL
THE INFORMATION CONTAINED IN THIS DRAWING IS
THE SOLE PROPERTY OF BENDA'R INC. ANY
REPRODUCTION IN PART OR AS A WHOLE WITHOUT
THE WRITTEN PERMISSION OF BENDPAK INC. IS
PROHIBITED.

SCALE: 1:4

SIZE DWG. NO.

REV


D

SCALE: 1:4


SHEET 1 OF 1

. ASSEMBLE ITEMS AS SHOWN

NEXT ASSEMBLY 5245233

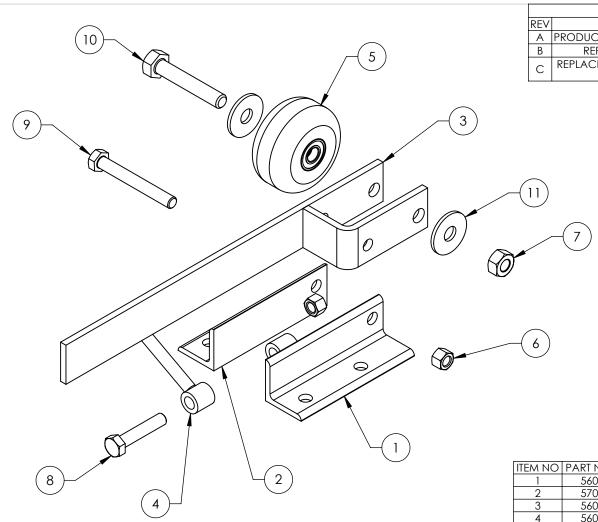

	REVISION				
REV	DESCRIPTION	DATE	EDITED BY	ECO#	
Α	PRODUCTION RELEASE, DERIVED FROM T1034	10/05/2010	TM	00406	
В	REPLACED 5535998 WITH 5535013	02/02/2017	TS	00808	
С	REPLACED 5215224 WITH 5215872, UPDATED BOM REVISION	09/23/2019	CA	01128	

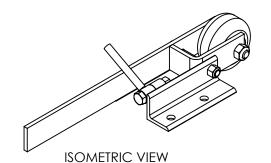

FOR REFERENCE ONLY DO NOT SCALE

ITEM NO	PART NUMBER	DESCRIPTION	QTY	REV
1	5600527	LR-60P WHEEL MOUNTING ANGLE WELDMENT	1	Α
2	5701332	LR-60P MOUNTING ANGLE LH	1	Α
3	5600528	LR-60P WHEEL FRAME WELDMENT	1	Α
4	5600083	LR-60P WHEEL FRAME STOP WELDMENT	1	Α
5	5215872	LOW RISE TOW CART PLASTIC WHEEL ASSEMBLY	1	В
6	5535013	NUT M10 x 1.5 NL	2	-
7	5535012	NUT M12x1.75 NL	1	-
8	5530759	HHB M10 x 1.5 x 50	1	-
9	5530765	HHB M10 x 1.5 x 80	1	-
10	5530141	HHB M12 x 1.75 x 70	1	-
11	5545027	WASHER M12 x Ø37 x 3mm	2	-

DATE

WHERE USED LR-60P

NOTE: UNLESS OTHERWISE SPECIFIED.

- REFER TO MODEL FOR ADDITIONAL INFORMATION
- 2. SEE SHIPPING INSTRUCTIONS FOR FINAL PACKAGING
- 3.
- ASSEMBLE ITEMS AS SHOWN 5600528 & 5215872 MUST ROTATE FREELY 4.

DO NOT SCALE DRAWING

DIMENSIONS ARE IN MM

DRAWN TM 10/05/2010 CHECKED THIRD ANGLE PROJECTION TITLE:

NAME

PROPRIETARY AND CONFIDENTIAL
THE INFORMATION CONTAINED IN THIS DRAWING IS
THE SOLE PROPERTY OF BENDFAK INC. ANY
REPRODUCTION IN PART OR AS A WHOLE WITHOUT
THE WRITTEN PERMISSION OF BENDPAK INC. IS
PROHIBITED.

LR-60P WHEEL BRACKET **ASSEMBLY**

BP BendPak.

1645 LEMONWOOD DR. SANTA PAULA, CA 93060

SIZE DWG. NO.

5210907

SCALE: 1:3 SHEET 1 OF 2

REV

С

NEXT ASSEMBLY 5260168



PART SPECIFICATION FORM ACP

BENDPAK Number:	5570129
MRP Description:	1/4" HYDRAULIC HOSE 31 CL-0400X
Date:	05/24/2018
ECO:	00950

1. Engineering Specification

Application:

1/4" HYDRAULIC HOSE

Detailed Description:

ONE or TWO BRAID STEEL WIRE HYDRAULIC HOSE

SIZE: 1/4" / 6mm I.D. MIN

0.53" / 13.4mm O.D. MAX

SPECS: 5700PSI OR 393 BAR WORKING PRESSURE MINIMUM

17100PSI OR 1179 BAR MINIMUM BURST PRESSURE MINIMUM

3" / 80mm MIN BEND RADIUS

COLOR: BLACK

ADDITIONAL CONTACT INFORMATION:

Xin Yurong

Shandong Ningjin High Energy Hose Co., Ltd.

Tel: +86 534-5421821

No. 7, Taishan Rd., Industrial Park, Ningjin County, Shandong, China




2. Vendor Information (Or for Reference)

Approved Vendor	Vendor Part #	Contact #	AUTHORIZED COMPONENT PROVIDER
1) Ningjin Hydraulic Hose Co.	5570129	+86 534-5421821	х
2)			

OR BENDPAK ENGINEERING APPROVED EQUIVALENT

	REVISION			
REV	DESCRIPTION	DATE	EDITED BY	ECO#
A	PRODUCTION RELEASE, DERIVED FROM 5570233	08/11/2020	TM	01188

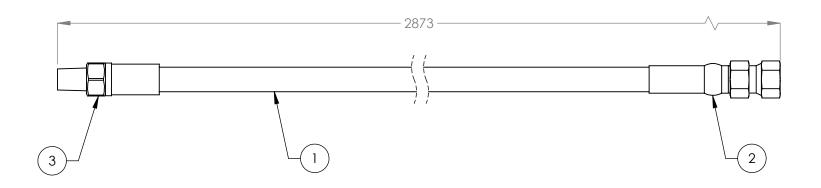

WHERE USED
DLR-6P
LR-40P

NOTE: UNLESS OTHERWISE SPECIFIED.

FOR ITEM 1 SPECIFICATIONS REFER TO PART SPECIFICATION FORM (*) ITEM 1 QTY FOR REFERENCE ONLY 2.

	DIMENSIONS ARE IN MM TOLERANCES: 0. = ±1.5 0.0 = ±1.0 0.00 = ±0.25 0.000 = ±0.13
	SURFACE FINISH 1.6 ISO Ra µm FOR MACHINED SURFACES
NEXT ASSEMBLY	UNLESS OTHERWISE SPECIFIED
5250020	
5250318	

3

ITEM NO. PART NUMBER DESCRIPTION QTY. REV 5570129 Ø6.4 ID HYDRAULIC HOSE 2811mm* 5550325 FTG NPL Ø1/4 CRIMP x -04 JIC 5550060 FTG NPL Ø1/4 CRIMP x -04 NPT M DO NOT SCALE DRAWING


,	000		11011	,	,,,,,,	/
;			NAME	DATE	-	
	DRAWI	N	TM	08/11/2020	<u> </u>	
	CHECK	D	OR	8/18/2020		
	THIR	A D	NGLE PRO	DJECTION	HY	: /DI Q
m					SIZE	DW
0	THE INFORMATHE SOLE PRO	TION C	OF BENDPAK	THIS DRAWING IS	Α	
			SION OF BEND			5


1645 LEMONWOOD DR. SANTA PAULA, CA 93060 RAULIC HOSE ASSEMBLY 26.4 x 2873mm DS-M VG. NO. REV

5570244


SCALE: 1:5 SHEET 1 OF 1

Α

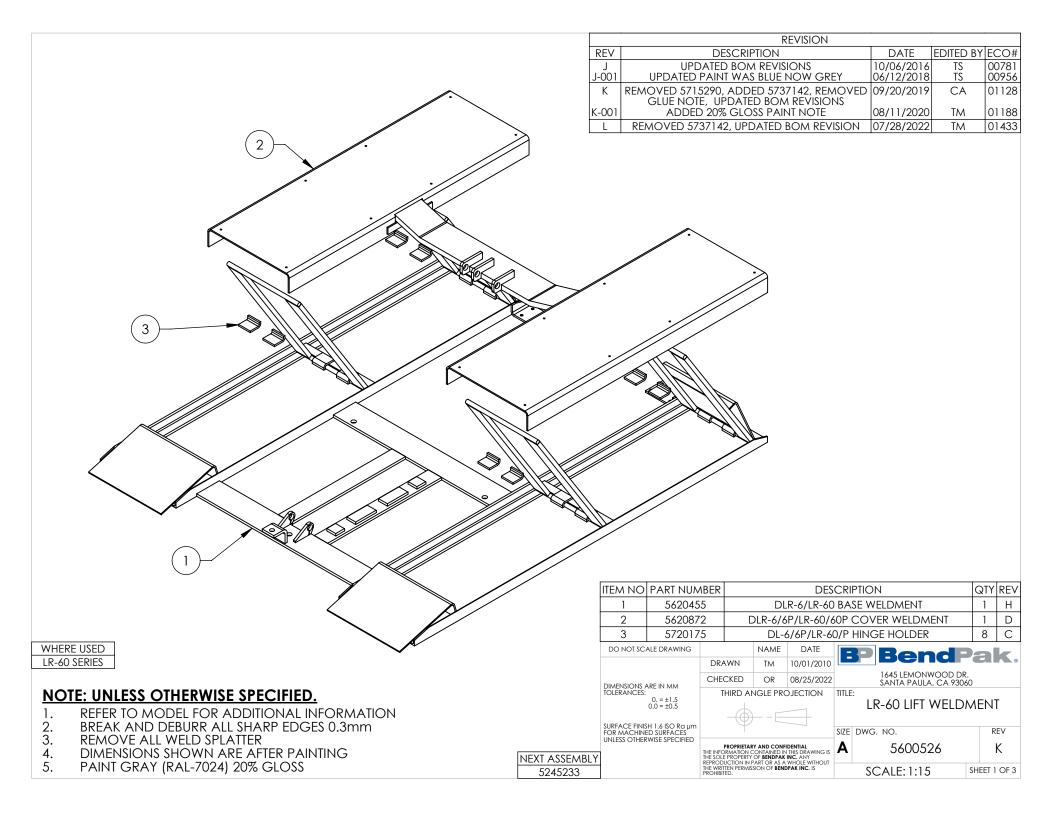

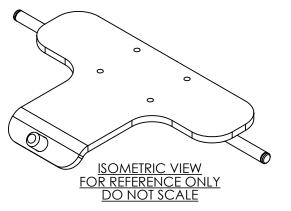

REVISION					
	REV	DESCRIPTION	DATE	EDITED BY	ECO#
	Α	PRODUCTION RELEASE, DERIVED FROM 5600187	09/12/2019	TM	01128 -PRE
	A-001	ADDED 20% GLOSS PAINT NOTE	08/11/2020	TM	01188
	В	REMOVED 5746130, WAS 55 NOW 45, UPDATED COLOR, WAS GRAY NOW BLACK, UPDATED BOM REVISIONS	07/15/2021	СА	01317

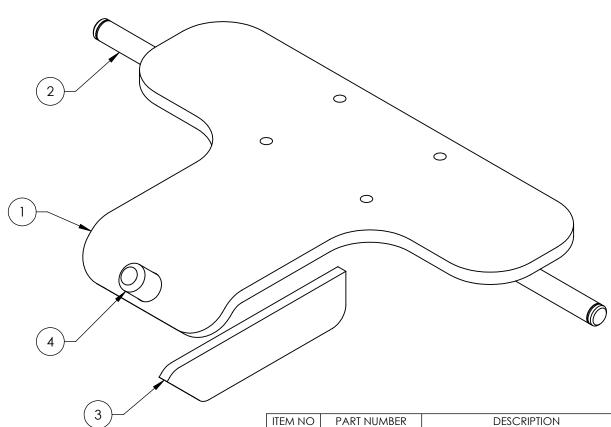

NEXT ASSEMBLY

5215871

WHERE USED
LR-60P
MD-6XP
DMR-6
DLR-6P

NOTE: UNLESS OTHERWISE SPECIFIED.

- 1. REFER TO MODEL FOR ADDITIONAL INFORMATION
- 2. BREAK AND DEBURR ALL SHARP EDGES 0.3mm
- 3. REMOVE ALL WELD SPLATTER
- 4. DIMENSIONS SHOWN ARE AFTER PAINTING
- 5. PAINT BLACK (RAL-9017) 20% GLOSS

ITEM NO	PART NUMBER	DESCRIPTION	QTY	REV
1	5730083	LOW RISE TOW CART BASE PLATE	1	В
2	5746122	LOW RISE TOW CART AXLE	1	В
3	5737140	LOW RISE TOW CART SUPPORT BAR	1	В
4	5746129	LOW RISE TOW CART PIN	1	С

DO NOT SCALE DRAWING

DRAWN

TM

09/12/2019

CHECKED

OR

07/22/2021

THIRD ANGLE PROJECTION

TITLE:

SURFACE FINISH 1.6 SOR BUT FOR MACHINED SURFACES
UNLESS OTHERWISE SPECIFIED

DIMENSIONS ARE IN MM

TOLERANCES:

SURFACE FINISH 1.6 SOR BUT FOR MACHINED SURFACES
UNLESS OTHERWISE SPECIFIED

21 1645 LEMONWOOD DR.
SANTA PAULA, CA 93060

TITLE: LOW RISE TOW CART
BASE WELDMENT

SIZE DWG. NO. REV


BendPak.


THE INFORMATION CONTIDENTIAL


THE INFORMATION CONTAINED IN THIS DRAWING IS
THE SOLE PROPERTY OF BENDPAK INC. ANY
REPRODUCTION IN PART OR AS A WHOLE WITHOUT
THE WRITEN PERMISSION OF BENDPAK INC. IS


5601405 SCALE: 1:2

B SHEET 1 OF 2

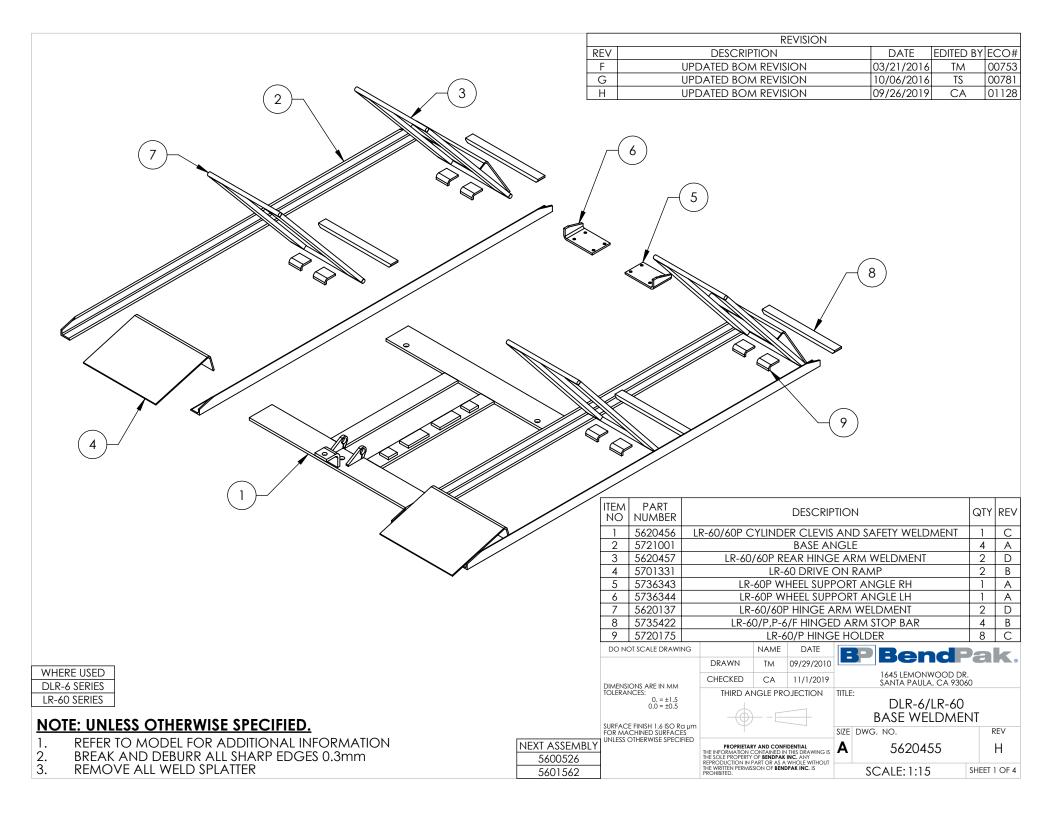

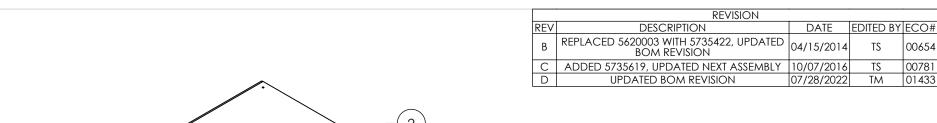

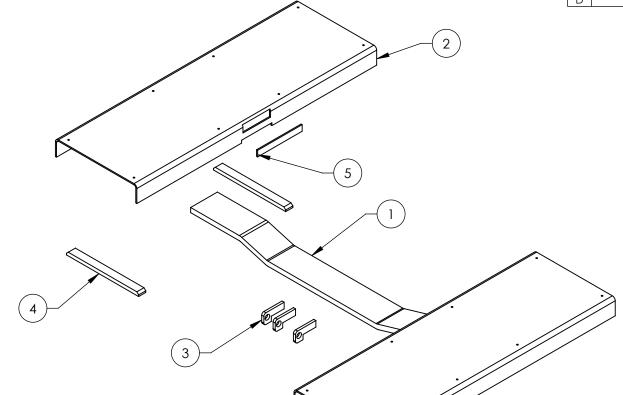

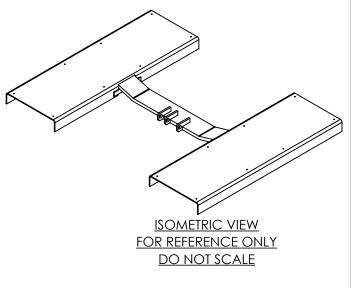

ITEM NO	PART NUMBER	DESCRIPTION		REV
1	5736342	LR-60/60P PUSH BAR	1	Α
2	5701333	DLR/LR-60/60P RAMP COVER	2	В
3	5736338	LR-60/60P TOP CLEVIS	3	Α
4	5735422	LR-60/P,P-6/F HINGED ARM STOP BAR	4	В
5	5735619	LR-60/60P COVER REINFORCEMENT STRIP	2	Α

DATE

WHERE USED
DLR-6 SERIES
LR-60 SERIES

NOTE: UNLESS OTHERWISE SPECIFIED.

- 1. REFER TO MODEL FOR ADDITIONAL INFORMATION
- 2. BREAK AND DEBURR ALL SHARP EDGES 0.3mm

3. REMOVE ALL WELD SPLATTER

NEXT ASSEMBLY 5600526 5601562

DO NOT SCALE DRAWING

0. = ±1.5 0.0 = ±0.5

DIMENSIONS ARE IN MM TOLERANCES:

DRAWN TM 10/01/2010

CHECKED OR 08/25/2022

THIRD ANGLE PROJECTION TITLE:

NAME

SURFACE FINISH 1.6 ISO Ra µm
FOR MACHINED SURFACES
UNLESS OTHERWISE SPECIFIED

PROPRIETARY AND CONFIDENTIAL
THE INFORMATION CONTAINED IN THIS DRAWING IS
THE SOLE PROPERTY OF BENDPAK INC. ANY
REPRODUCTION IN PART OR AS A WHOLE WITHOUT
THE WRITTEN PERMISSION OF BENDPAK INC. IS

BP BencPak。

1645 LEMONWOOD DR.
SANTA PAULA, CA 93060

DLR-6/6P/LR-60/60P COVER WELDMENT

SIZE DWG. NO. 5620872

SCALE: 1:15 SHEET 1 OF 2

REV

D



PART SPECIFICATION FORM STANDARD

BENDPAK Number:	mber: 5900337	
MRP Description:	LR-60/60P INSTALLATION MANUAL	
Date:	12/09/2020	
ECO:		

1. Engineering Specification

Application:

INSTALLATION MANUAL

Detailed Description:

Print Settings for BendPak Manuals

Unless otherwise specified, use these settings for printing BendPak manuals:

- Color: Black and white.
- Size: A4 (210 to 297 mm), 8.5 by 11 inches (216 to 279 mm), or between
- Binding: Saddle stitched
- Paper: 100 to 120 gsm (27 to 32 pound), uncoated



2. Vendor Information (2. Vendor Information (Or for Reference)				
Approved Vendor	Vendor Part #	Contact #	Preferred Vendor		
1)					
OR BENDPAK ENGINEERING APPROVED EQUIVALENT					







info@bendpak.com

